


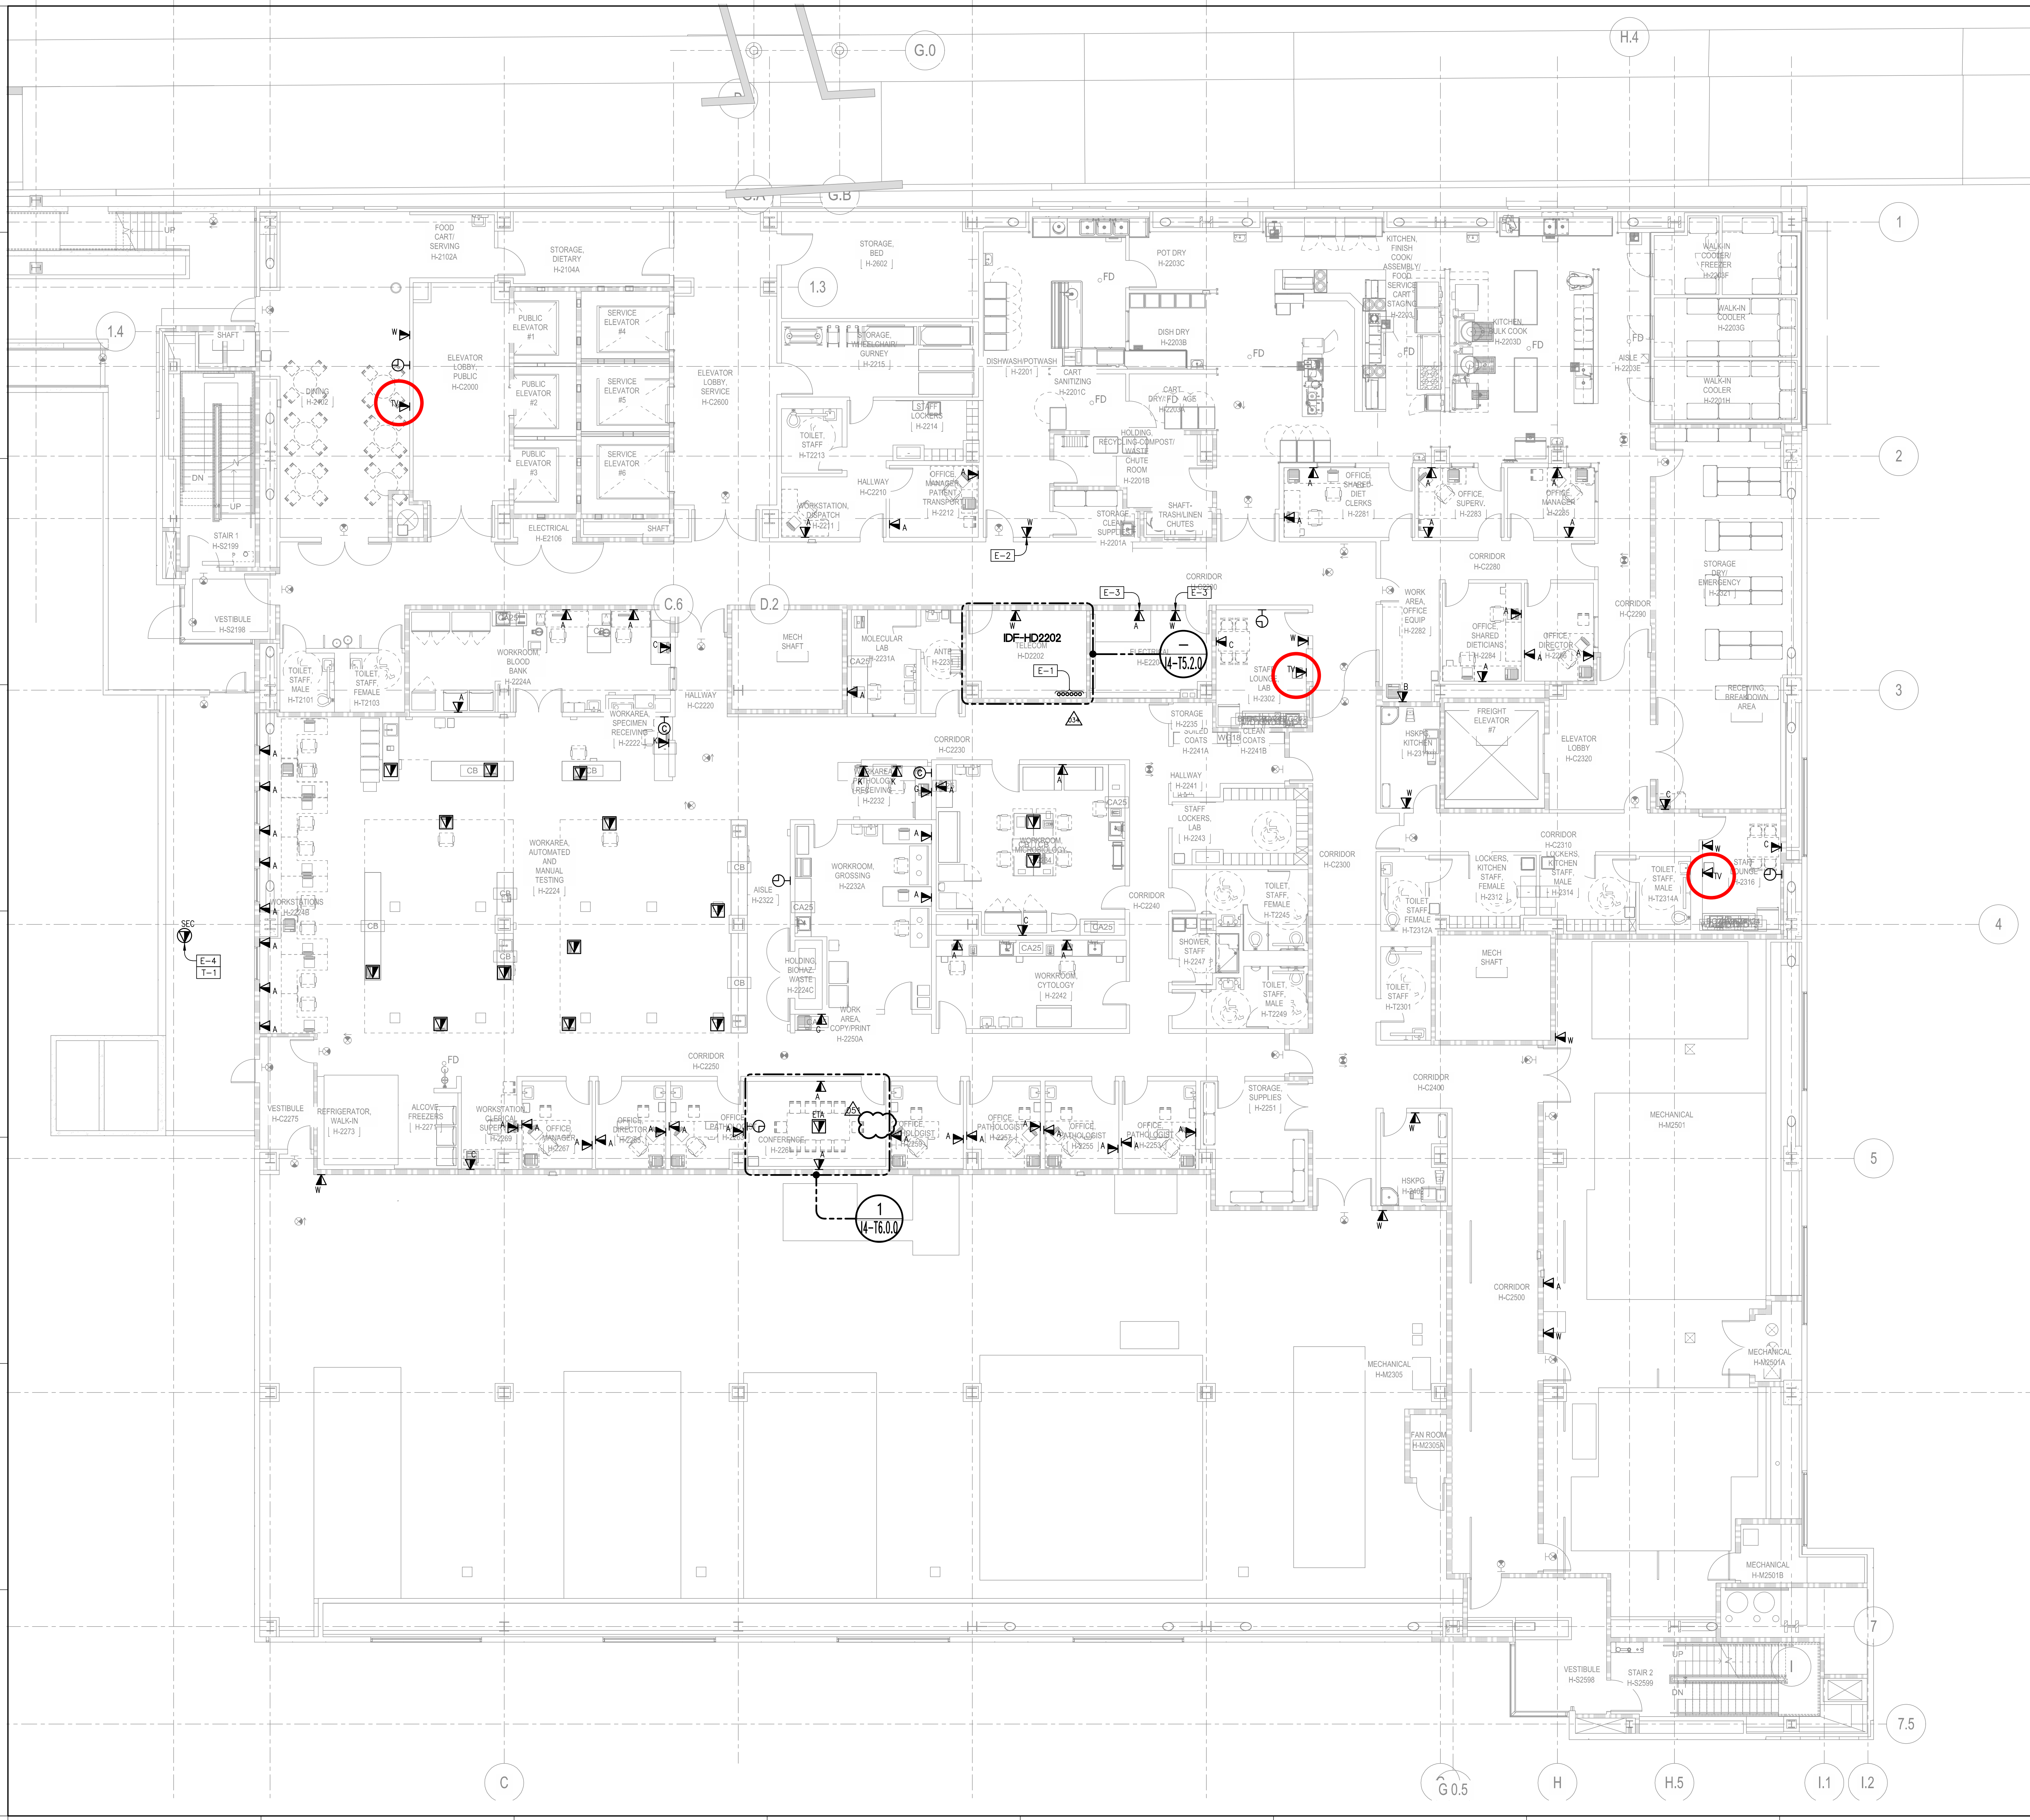

SHEET NOTES

- SERVE TELECOMMUNICATIONS DEVICES ON THIS SHEET FROM IDF-HD2202.
- PATHWAYS SHOWN DEDICATED FOR LOW VOLTAGE CABLING ONLY, UON.
- PATHWAYS ROUTES SHOWN CONCEPTUAL. FIELD COORDINATE FINAL ROUTES.
- FIRESTOP PENETRATIONS (SLEEVES AND CONDUITS) THROUGH RATED WALLS AND FLOORS TO MATCH WALL RATING.
- WHERE SHOWN, ARCHITECTURAL PLANS GOVERN EXACT LOCATION OF TELECOMMUNICATIONS DEVICES.
- LABEL CONDUITS AT BOTH ENDS. LABEL MUST INDICATE CONDUIT'S DEDICATED USE FOR TELECOMMUNICATIONS CABLING AND LOCATION OF THE CONDUIT'S FAR END.
- PROVIDE BUSHINGS ON CONDUIT AND SLEEVE ENDS.
- FOR TELECOM PATHWAYS ENTERING THE TELECOM ROOM, REFER TO 14-T0.10.0 FOR SIZE, QUANTITY, AND TYPE.

KEYED NOTES

TELECOMMUNICATIONS:

- T-1 PROVIDE OSP RATED CABLING FOR THIS CONNECTION.

ELECTRICAL:

- E-1 PROVIDE RISER CONDUITS TO FLOOR BELOW.
E-2 HOMERUN OUTLET CONDUIT TO CABLE TRAY.
E-3 HOMERUN OUTLET CONDUIT INTO IDF-HD2202.
E-4 HOMERUN OUTLET CONDUIT TO IDF-HD2202. PROVIDE JUNCTION BOX AFTER THREE 90-DEGREE TURNS. THIS CONDUIT WILL HOUSE OSP CABLE.



DESIGN/BUILDER



7677 Oakport Street, Suite 1040, Oakland, CA 94621
Phone: 510.430.1700 Fax: 510.430.1705

ARCHITECT:

SMITHGROUP

301 Battery Street, 7th Floor, San Francisco, CA 94111
Phone: 415.227.0100

ASSOCIATE ARCHITECTS:

RATCLIFF

5856 Doyle Street, Emeryville, CA 94608
Phone: 510.899.6400

SHAH KAWASAKI ARCHITECTS

1111 Broadway, Suite 1650, Oakland, CA 94607
Phone: 510.663.6090

All reproduction & intellectual property rights reserved © 2011
In Association with

BKF Engineers

Civil Engineers

Degenkolb

Structural Engineers

Gutmann & Blaevoet

Mechanical/Plumbing Engineers

F.W. Associates, Inc.

Consulting Engineers

TEECOM Design Group

Information Systems Engineers

Criterion Systems, Inc.

Medical Equipment Planning

Keller Mitchell & Co.

Landscape Architects

William Caruso and Associates

Food Service Consultant


Square Peg Design

Signage Consultant

SEALS AND SIGNATURES



KEY PLAN

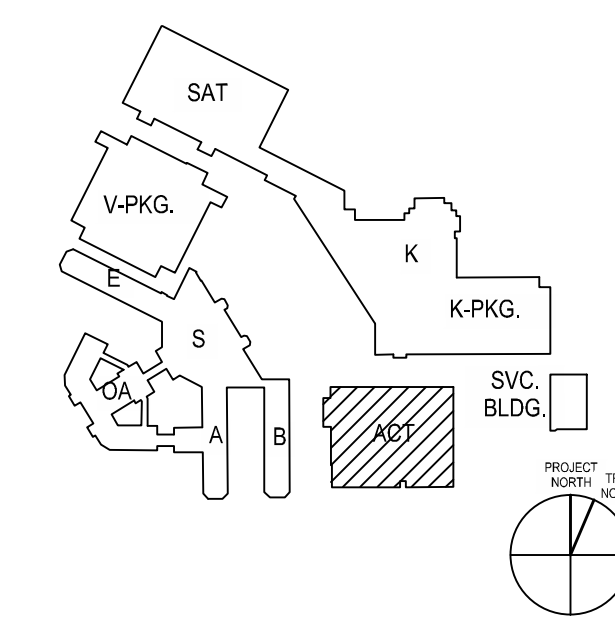

No.	ISSUE DESCRIPTION	DATE
0	INCORPORATE 4	14 OCT 11
1	14 OSHPD BACKCHECK NO. 1	05 MAR 12
3	14 PERMIT SET	13 DEC 12
4	ACD 14-034	01 JUN 13
5	ACD 14-051	17 JUN 14

ACUTE CARE TOWER

DRAWING TITLE

FLOOR PLAN LEVEL 2


SCALE 1/8" = 1'-0"

OSHPD NO. IS101717-4

PROJECT NUMBER 38385.000

DRAWING NUMBER

14-T2.2.0

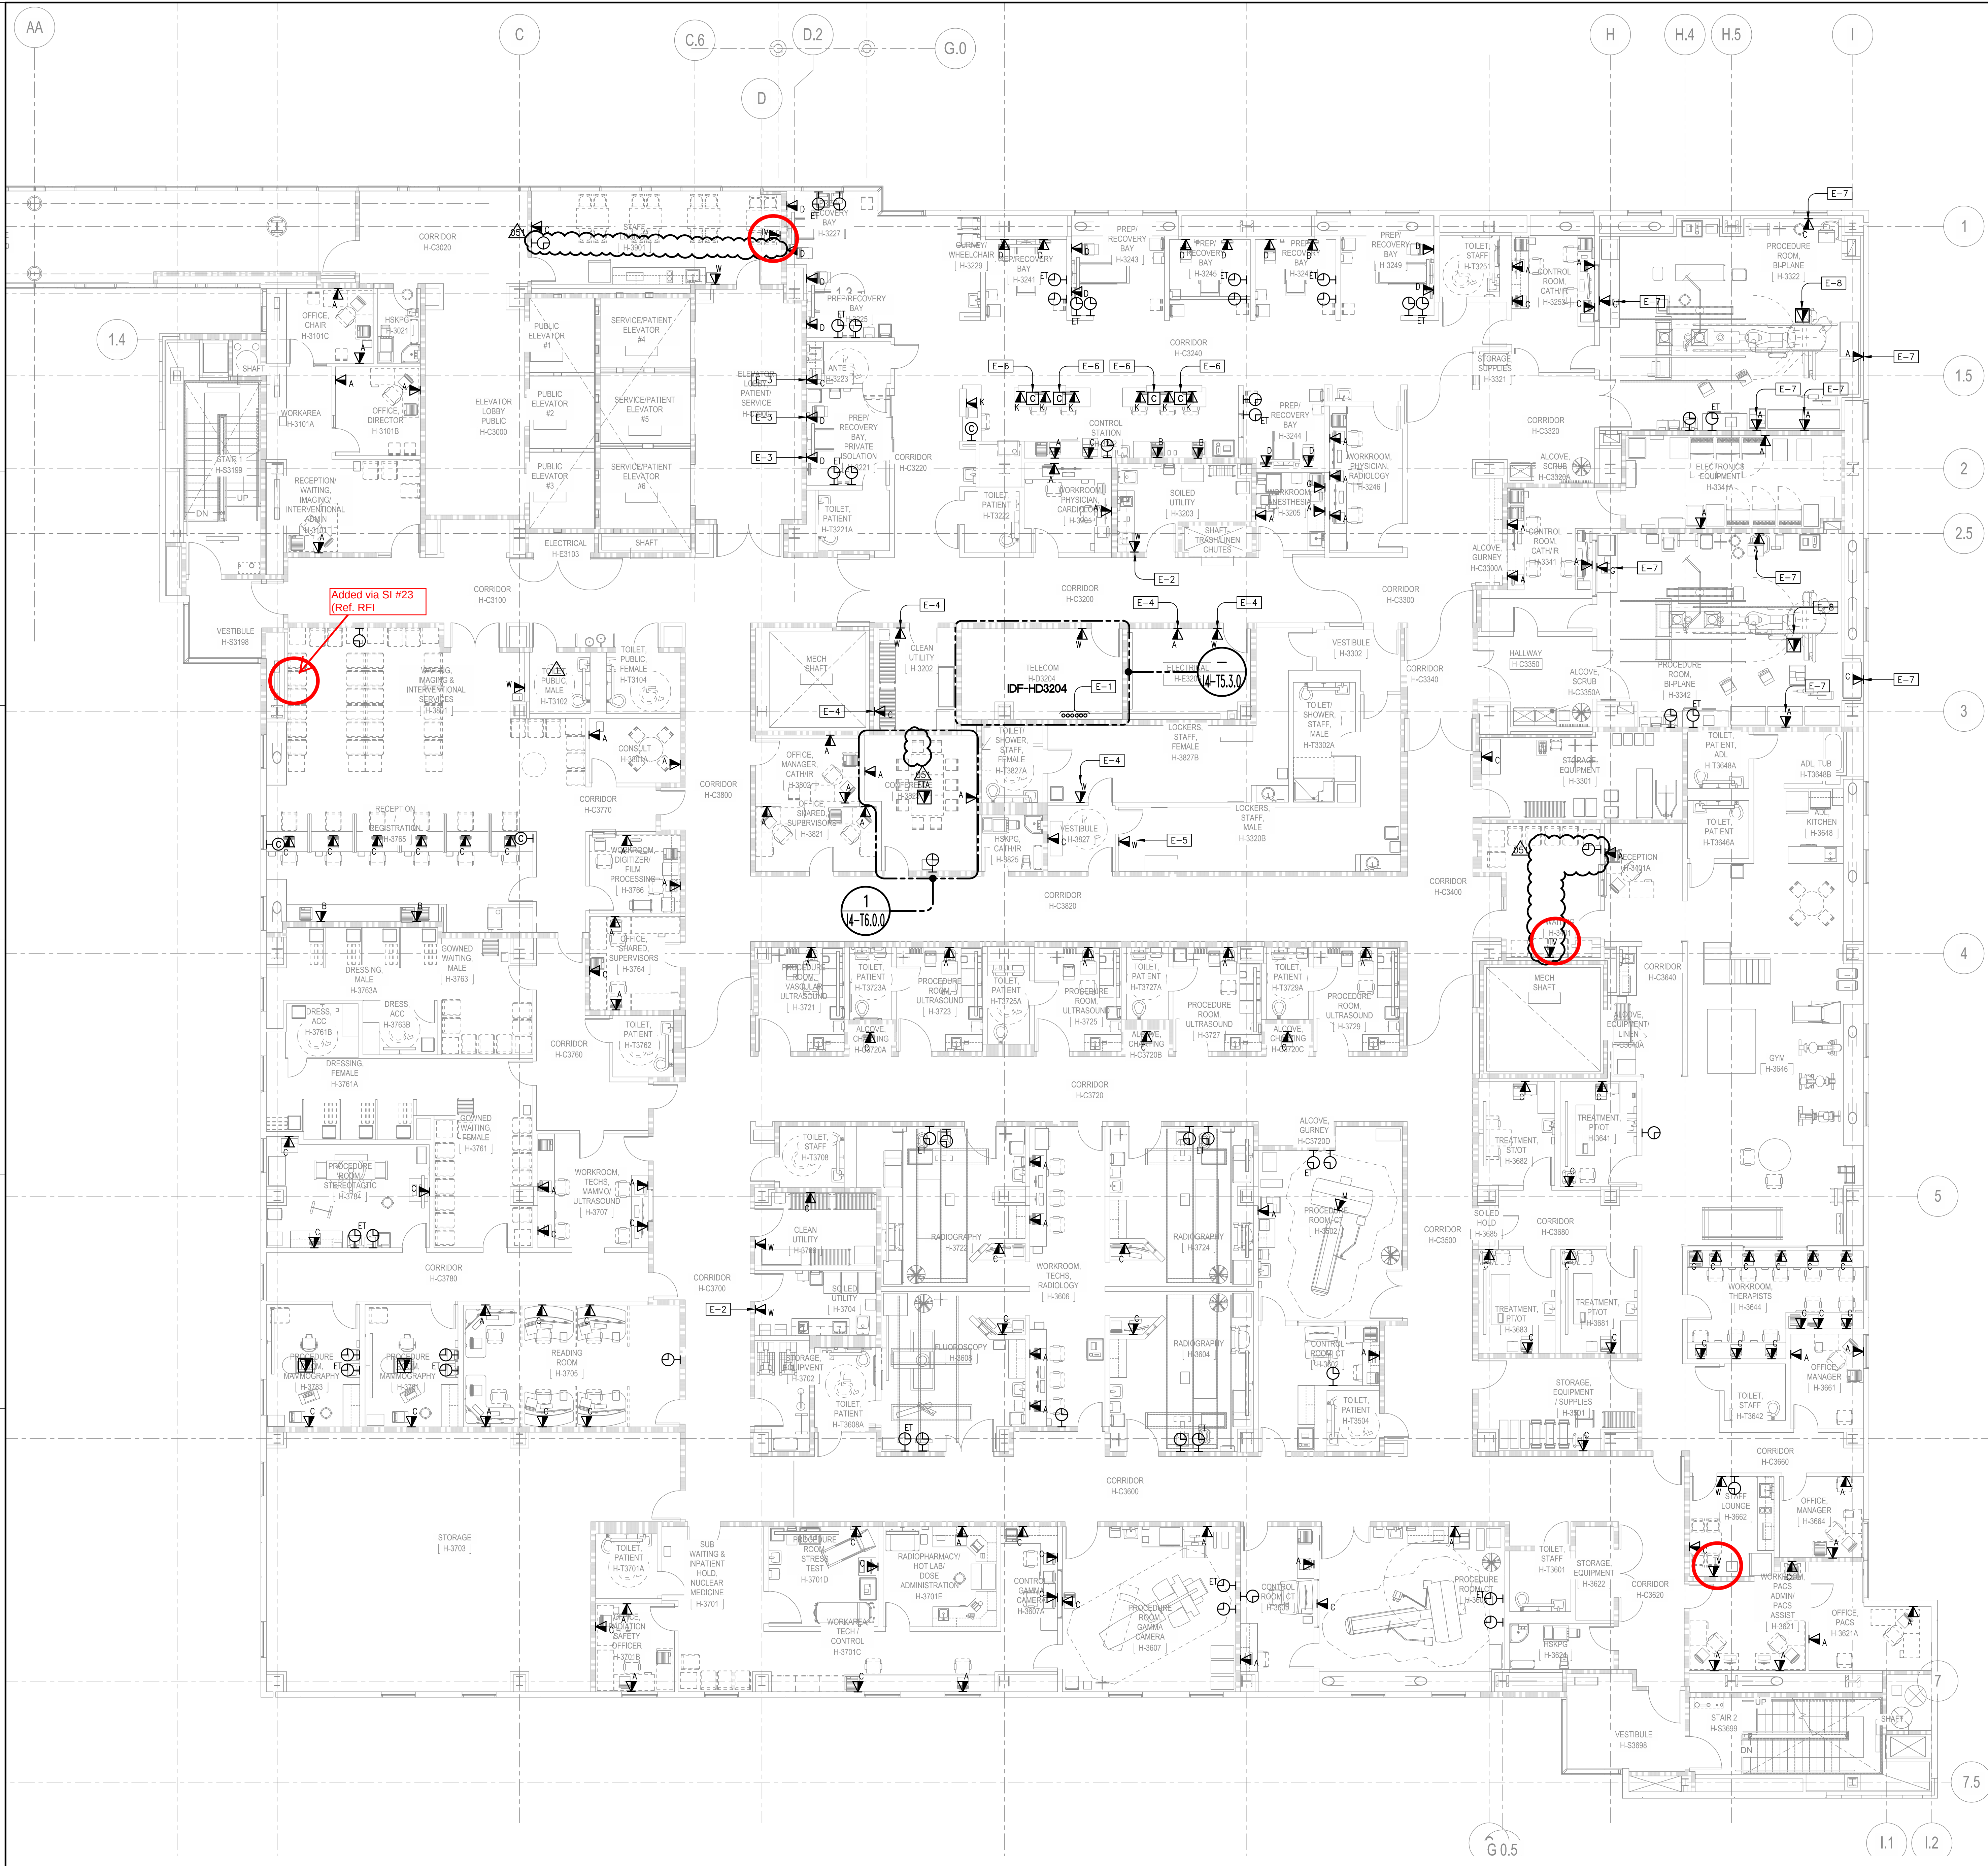

SHEET NOTES

- SERVE TELECOMMUNICATIONS DEVICES ON THIS SHEET FROM IDF-HD3204.
- PATHWAYS SHOWN DEDICATED FOR LOW VOLTAGE CABLING ONLY, UON.
- PATHWAYS ROUTES SHOWN CONCEPTUAL. FIELD COORDINATE FINAL ROUTES.
- FIRESTOP PENETRATIONS (SLEEVES AND CONDUITS) THROUGH RATED WALLS AND FLOORS TO MATCH WALL RATING.
- WHERE SHOWN, ARCHITECTURAL PLANS GOVERN EXACT LOCATION OF TELECOMMUNICATIONS DEVICES.
- LABEL CONDUITS AT BOTH ENDS. LABEL MUST INDICATE CONDUIT'S DEDICATED USE FOR TELECOMMUNICATIONS CABLING AND LOCATION OF THE CONDUIT'S FAR END.
- PROVIDE BUSHINGS ON CONDUIT AND SLEEVE ENDS.
- FOR TELECOM PATHWAYS ENTERING THE TELECOM ROOM, REFER TO 14-T0.10 FOR SIZE, QUANTITY, AND TYPE.

KEYED NOTES

- ELECTRICAL:**
- E-1 PROVIDE RISER CONDUITS TO FLOOR BELOW.
 - E-2 STUB OUTLET CONDUIT INTO CORRIDOR.
 - E-3 HOMERUN OUTLET CONDUIT TO ACCESSIBLE CEILING SPACE.
 - E-4 HOMERUN OUTLET CONDUIT TO IDF-HD3204.
 - E-5 STUB OUTLET CONDUIT INTO CORRIDOR.
 - E-6 ROUTE DEVICE CONDUIT TO CABLE TRAY ON LEVEL BELOW.
 - E-7 STUB OUTLET CONDUIT INTO CORRIDOR.
 - E-8 ROUTE DEVICE CONDUIT TO CABLE TRAY ON LEVEL BELOW.

ALAMEDA COUNTY MEDICAL CENTER

AIR
HIGHLAND HOSPITAL
Acute Tower Replacement Project
1411 EAST 31ST STREET, OAKLAND, CA 94612

PREPARED FOR:
GENERAL SERVICES AGENCY
COUNTY OF ALAMEDA
1401 LAKESIDE DRIVE, 10TH FLOOR
OAKLAND, CA 94612

DESIGN/BUILDER:
CLARK
DESIGN + BUILD
OF CALIFORNIA
7677 Oakport Street, Suite 1040, Oakland, CA 94621
Phone: 510.430.1700 Fax: 510.430.1705

ARCHITECT:
SMITHGROUP
301 Battery Street, 7th Floor, San Francisco, CA 94111
Phone: 415.227.0100

ASSOCIATE ARCHITECTS:
RATCLIFF
5856 Doyle Street, Emeryville, CA 94608
Phone: 510.699.6400

SHAH KAWASAKI ARCHITECTS
1111 Broadway, Suite 1650, Oakland, CA 94607
Phone: 510.663.6090

All reproduction & intellectual property rights reserved © 2011
In Association with

BKF Engineers
Civil Engineers

Degenkolb
Structural Engineers

Gutmann & Blevett
Mechanical/Plumbing Engineers

F.W. Associates, Inc.
Consulting Engineers

TEECOM Design Group
Information Systems Engineers


Criterion Systems, Inc.
Medical Equipment Planning

Keller Mitchell & Co.
Landscape Architects


William Caruso and Associates
Food Service Consultant

Square Peg Design
Signage Consultant

SEALS AND SIGNATURES

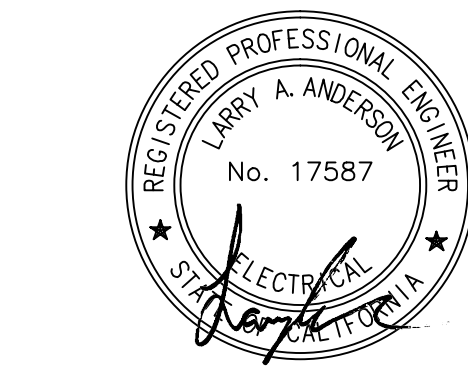

KEY PLAN

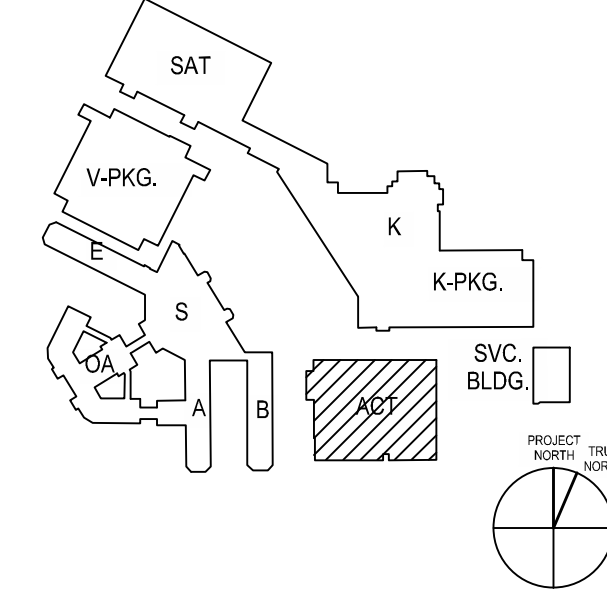

No.	ISSUE DESCRIPTION	DATE
0	INCORPORATE 4 14 OSHPD BACKCHECK NO. 1 14 PERMIT SET ACD 14-051	14 OCT 11 05 MAR 12 13 DEC 12 17 JAN 14

ACUTE CARE TOWER

DRAWING TITLE

FLOOR PLAN LEVEL 3


SCALE 1/8" = 1'-0"

OSHPD NO. IS101717-4

PROJECT NUMBER 38385.000

DRAWING NUMBER

14-T2.3.0

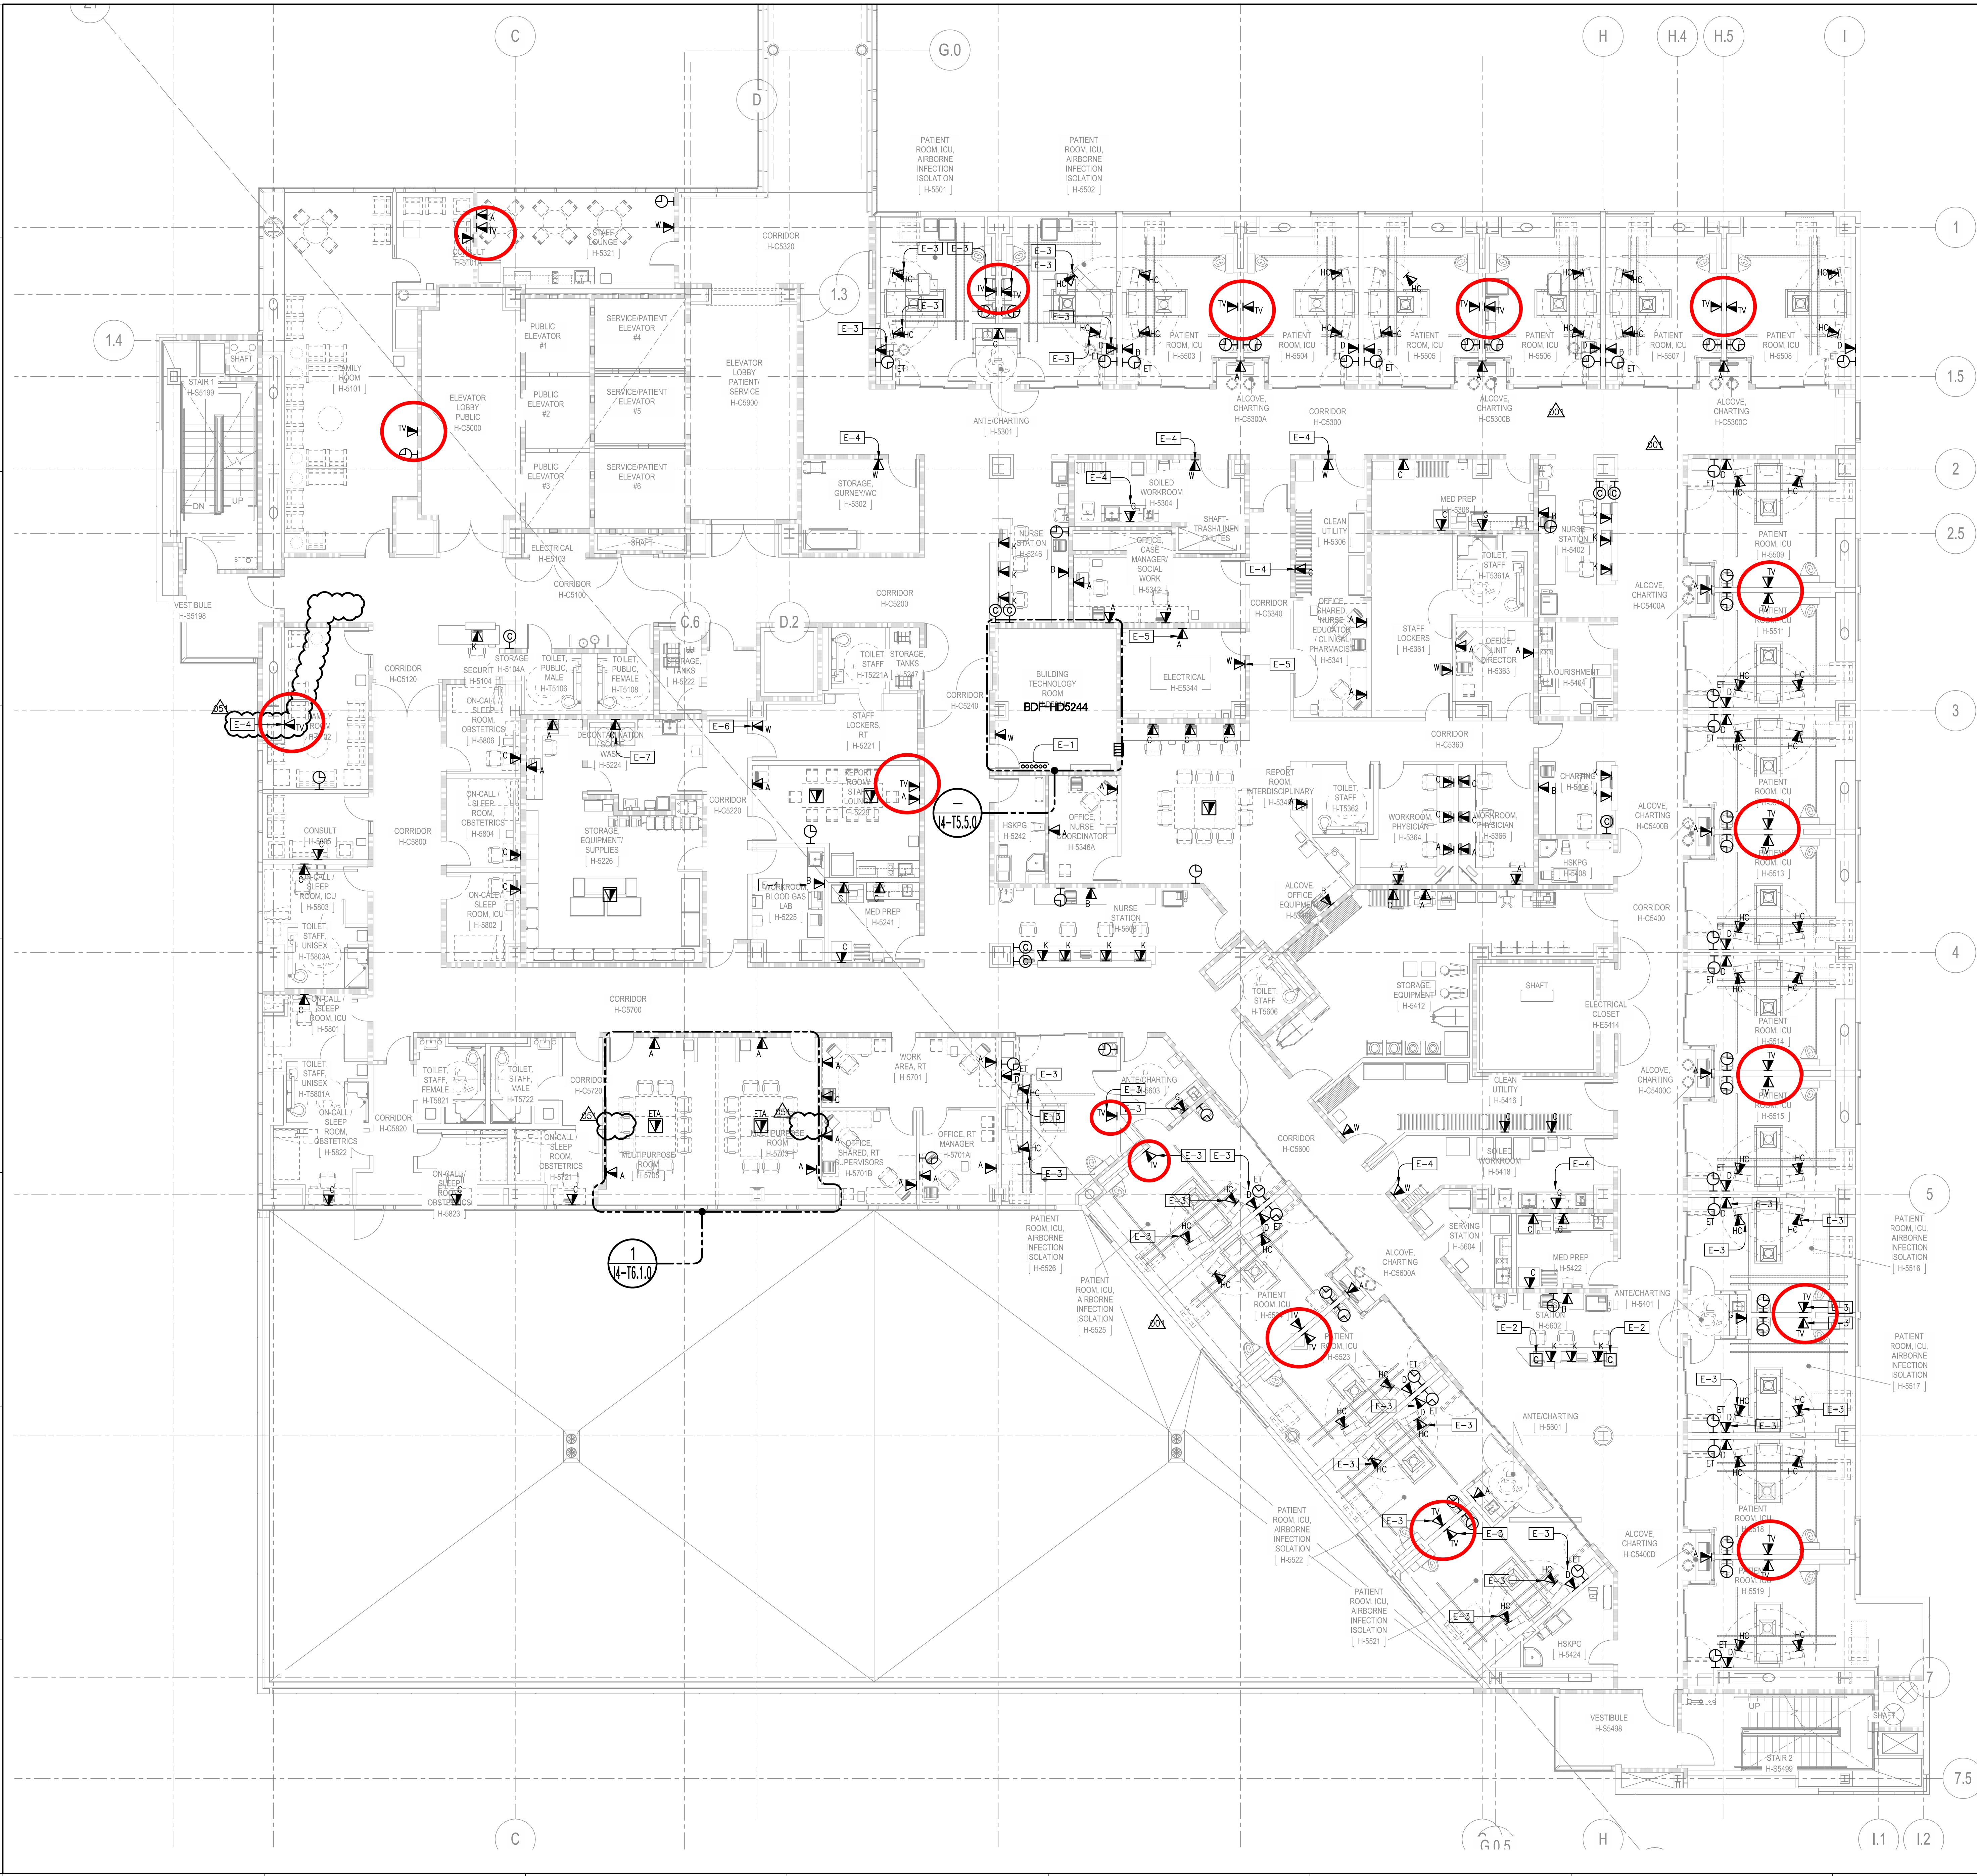

SHEET NOTES

- SERVE TELECOMMUNICATIONS DEVICES ON THIS SHEET FROM IDF-HD5244.
- PATHWAYS SHOWN DEDICATED FOR LOW VOLTAGE CABLEING ONLY, UON.
- PATHWAYS ROUTES SHOWN CONCEPTUAL. FIELD COORDINATE FINAL ROUTES.
- FIRESTOP PENETRATIONS (SLEEVES AND CONDUITS) THROUGH RATED WALLS AND FLOORS TO MATCH WALL RATING.
- WHERE SHOWN, ARCHITECTURAL PLANS GOVERN EXACT LOCATION OF TELECOMMUNICATIONS DEVICES.
- LABEL CONDUITS AT BOTH ENDS. LABEL MUST INDICATE CONDUIT'S DEDICATED USE FOR TELECOMMUNICATIONS CABLEING AND LOCATION OF THE CONDUIT'S FAR END.
- PROVIDE BUSHINGS ON CONDUIT AND SLEEVE ENDS.
- FOR TELECOM PATHWAYS ENTERING THE TELECOM ROOM, REFER TO I4-10.10.0 FOR SIZE, QUANTITY, AND TYPE.

KEYED NOTES

- ELECTRICAL:**
- E-1 PROVIDE RISER CONDUITS TO FLOOR BELOW.
 - E-2 ROUTE DEVICE CONDUIT TO CABLE TRAY ON LEVEL BELOW.
 - E-3 HOMERUN OUTLET CONDUIT TO CABLE TRAY.
 - E-4 STUB OUTLET CONDUIT INTO CORRIDOR.
 - E-5 HOMERUN OUTLET CONDUIT INTO BDF-HD5244.
 - E-6 STUB OUTLET CONDUIT INTO ROOM H5223.
 - E-7 STUB OUTLET CONDUIT INTO ROOM H5226.



DESIGN/BUILDER
CLARK
DESIGN • BUILD • CALIFORNIA
7677 Oakport Street, Suite 1040, Oakland, CA 94621
Phone: 510.430.1700 Fax: 510.430.1705

ARCHITECT:
SMITHGROUP
301 Battery Street, 7th Floor, San Francisco, CA 94111
Phone: 415.227.0100

ASSOCIATE ARCHITECTS:
RATCLIFF
5856 Doyle Street, Emeryville, CA 94608
Phone: 510.899.6400

SHAH KAWASAKI ARCHITECTS
1111 Broadway, Suite 1650, Oakland, CA 94607
Phone: 510.663.6090

All reproduction & intellectual property rights reserved © 2011
In Association with

BKF Engineers
Civil Engineers

Degenkolb
Structural Engineers

Guttmann & Blaesovet
Mechanical/Plumbing Engineers

F.W. Associates, Inc.
Consulting Engineers

TECDOM Design Group
Information Systems Engineers


Criterion Systems, Inc.
Medical Equipment Planning

Keller Mitchell & Co.
Landscape Architects

William Caruso and Associates
Food Service Consultant

Square Peg Design
Signage Consultant

SEALS AND SIGNATURES

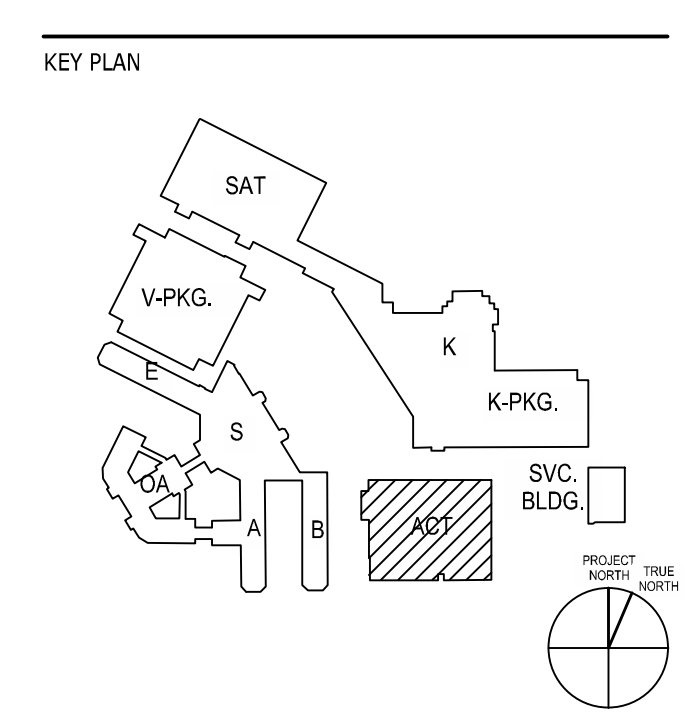

No.	ISSUE DESCRIPTION	DATE
0	INCORPORATE 4	14 OCT 11
1	14 PERMIT SET	13 DEC 12
2	ACD 14-001	08 MAR 13
3	ACD 14-051	17 JAN 14

ACUTE CARE TOWER

DRAWING TITLE

FLOOR PLAN LEVEL 5

SCALE 1/8" = 1'-0"

OSHPD NO. IS101717-4

PROJECT NUMBER 38385.000

DRAWING NUMBER

I4-T2.5.0



SHEET NOTES

- SERVE TELECOMMUNICATIONS DEVICES ON THIS SHEET FROM IDF-HD6204.
- PATHWAYS SHOWN DEDICATED FOR LOW VOLTAGE CABLING ONLY, UON.
- PATHWAYS ROUTES SHOWN CONCEPTUAL FIELD COORDINATE FINAL ROUTES.
- FIRESTOP PENETRATIONS (SLEEVES AND CONDUITS) THROUGH RATED WALLS AND FLOORS TO MATCH WALL RATING.
- WHERE SHOWN, ARCHITECTURAL PLANS GOVERN EXACT LOCATION OF TELECOMMUNICATIONS DEVICES.
- LABEL CONDUITS AT BOTH ENDS. LABEL MUST INDICATE CONDUIT'S DEDICATED USE FOR TELECOMMUNICATIONS CABLING AND LOCATION OF THE CONDUIT'S FAR END.
- PROVIDE BUSHINGS ON CONDUIT AND SLEEVE ENDS.
- FOR TELECOM PATHWAYS ENTERING THE TELECOM ROOM, REFER TO I4-T0.1.0 FOR SIZE, QUANTITY, AND TYPE.

KEYED NOTES

ELECTRICAL:

- E-1 PROVIDE RISER CONDUITS TO FLOOR BELOW.
- E-2 ROUTE DEVICE CONDUIT TO CABLE TRAY ON LEVEL BELOW.
- E-3 ROUTE DEVICE CONDUIT DOWN ADJACENT FULL HEIGHT WALL OR FURRED-OUT COLUMN.
- E-4 STUB OUTLET CONDUIT INTO CORRIDOR.
- E-5 HOMERUN OUTLET CONDUIT TO IDF-HD6204.



HIGHLAND HOSPITAL
Acute Tower Replacement Project
1411 EAST 31ST STREET, OAKLAND, CA 94612

PREPARED FOR:



DESIGN/BUILDER



7677 Oakport Street, Suite 1040, Oakland, CA 94621
Phone: 510.430.1700 Fax: 510.430.1705

ARCHITECT:

SMITHGROUP

301 Battery Street, 7th Floor, San Francisco, CA 94111
Phone: 415.227.0100

ASSOCIATE ARCHITECTS:

RATCLIFF

5856 Doyle Street, Emeryville, CA 94608
Phone: 510.899.6400

SHAH KAWASAKI ARCHITECTS

1111 Broadway, Suite 1650, Oakland, CA 94607
Phone: 510.663.6090

All reproduction & intellectual property rights reserved © 2011
In Association with

BKF Engineers

Civil Engineers

Degenkolb

Structural Engineers

Guttmann & Blaevoet

Mechanical/Plumbing Engineers

F.W. Associates, Inc.

Consulting Engineers

TEECOM Design Group

Information Systems Engineers

Criterion Systems, Inc.

Medical Equipment Planning

Keller Mitchell & Co.

Landscape Architects

William Caruso and Associates

Food Service Consultant


Square Peg Design

Signage Consultant

SEALS AND SIGNATURES



KEY PLAN

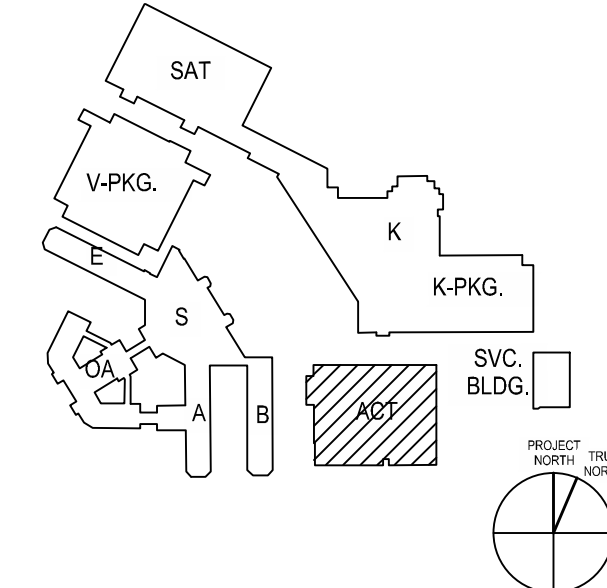

No.	ISSUE DESCRIPTION	DATE
0	INCORPORATE 4	14 OCT 11
073	14 PERMIT SET	13 DEC 12
073	ACD 14-073	11 OCT 13
073	ACD 14-051	17 JAN 14

ACUTE CARE TOWER

DRAWING TITLE

FLOOR PLAN LEVEL 6

SCALE 1/8" = 1'-0"

OSHPD NO. IS101717-4

PROJECT NUMBER 38385.000

DRAWING NUMBER

I4-T2.6.0



SHEET NOTES

- SERVE TELECOMMUNICATIONS DEVICES ON THIS SHEET FROM IDF-HD7204.
- PATHWAYS SHOWN DEDICATED FOR LOW VOLTAGE CABLING ONLY, UON.
- PATHWAYS ROUTES SHOWN CONCEPTUAL. FIELD COORDINATE FINAL ROUTES.
- FIRESTOP PENETRATIONS (SLEEVES AND CONDUITS) THROUGH RATED WALLS AND FLOORS TO MATCH WALL RATING.
- WHERE SHOWN, ARCHITECTURAL PLANS GOVERN EXACT LOCATION OF TELECOMMUNICATIONS DEVICES.
- LABEL CONDUITS AT BOTH ENDS. LABEL MUST INDICATE CONDUIT'S DEDICATED USE FOR TELECOMMUNICATIONS CABLING AND LOCATION OF THE CONDUIT'S FAR END.
- PROVIDE BUSHINGS ON CONDUIT AND SLEEVE ENDS.
- FOR TELECOM PATHWAYS ENTERING THE TELECOM ROOM, REFER TO I4-T0.10.0 FOR SIZE, QUANTITY, AND TYPE.

KEYED NOTES

ELECTRICAL:

- E-1 PROVIDE RISER CONDUITS TO FLOOR BELOW.
- E-2 ROUTE DEVICE CONDUIT TO CABLE TRAY ON LEVEL BELOW.
- E-3 ROUTE DEVICE CONDUIT DOWN ADJACENT FULL HEIGHT WALL OR FURRED-OUT COLUMN.
- E-4 STUB OUTLET CONDUIT INTO CORRIDOR.
- E-5 HOMERUN OUTLET CONDUIT TO IDF-HD7204.



HIGHLAND HOSPITAL
Acute Tower Replacement Project
1411 EAST 31ST STREET, OAKLAND, CA 94612

PREPARED FOR:



DESIGN/BUILDER



7677 Oakport Street, Suite 1040, Oakland, CA 94621
Phone: 510.430.1700 Fax: 510.430.1705

ARCHITECT:

SMITHGROUP

301 Battery Street, 7th Floor, San Francisco, CA 94111
Phone: 415.227.0100

ASSOCIATE ARCHITECTS:

RATCLIFF

5856 Doyle Street, Emeryville, CA 94608
Phone: 510.899.6400

SHAH KAWASAKI ARCHITECTS

1111 Broadway, Suite 1650, Oakland, CA 94607
Phone: 510.683.6090

All reproduction & intellectual property rights reserved © 2011
In Association with

BKF Engineers

Civil Engineers

Degenkolb

Structural Engineers

Guttmann & Blaesovot

Mechanical/Plumbing Engineers

F.W. Associates, Inc.

Consulting Engineers

TEECOM Design Group

Information Systems Engineers

Criterion Systems, Inc.

Medical Equipment Planning

Keller Mitchell & Co.

Landscape Architects

William Caruso and Associates

Food Service Consultant

Square Peg Design

Signage Consultant

SEALS AND SIGNATURES



SHEET NOTES

- SERVE TELECOMMUNICATIONS DEVICES ON THIS SHEET FROM IDF-HD8204.
- PATHWAYS SHOWN DEDICATED FOR LOW VOLTAGE CABLING ONLY, UON.
- PATHWAYS ROUTES SHOWN CONCEPTUAL FIELD COORDINATE FINAL ROUTES.
- FIRESTOP PENETRATIONS (SLEEVES AND CONDUITS) THROUGH RATED WALLS AND FLOORS TO MATCH WALL RATING.
- WHERE SHOWN, ARCHITECTURAL PLANS GOVERN EXACT LOCATION OF TELECOMMUNICATIONS DEVICES.
- LABEL CONDUITS AT BOTH ENDS. LABEL MUST INDICATE CONDUIT'S DEDICATED USE FOR TELECOMMUNICATIONS CABLING AND LOCATION OF THE CONDUIT'S FAR END.
- PROVIDE BUSHINGS ON CONDUIT AND SLEEVE ENDS.
- FOR TELECOM PATHWAYS ENTERING THE TELECOM ROOM, REFER TO 14-T0.10.0 FOR SIZE, QUANTITY, AND TYPE.

KEYED NOTES

ELECTRICAL:

- E-1 PROVIDE RISER CONDUITS TO FLOOR BELOW.
- E-2 ROUTE DEVICE CONDUIT TO CABLE TRAY ON LEVEL BELOW.
- E-3 ROUTE DEVICE CONDUIT DOWN ADJACENT FULL HEIGHT WALL OR FURRED-OUT COLUMN.
- E-4 STUB OUTLET CONDUIT INTO CORRIDOR.
- E-5 HOMERUN OUTLET CONDUIT TO IDF-HD8204.



HIGHLAND HOSPITAL
Acute Tower Replacement Project
1411 EAST 31ST STREET, OAKLAND, CA 94612

PREPARED FOR:



GENERAL SERVICES AGENCY
COUNTY OF ALAMEDA
1401 LAKESIDE DRIVE, 10TH FLOOR
OAKLAND, CA 94612

DESIGN/BUILDER



7677 Oakport Street, Suite 1040, Oakland, CA 94621
Phone: 510.430.1700 Fax: 510.430.1705

ARCHITECT:

SMITHGROUP

301 Battery Street, 7th Floor, San Francisco, CA 94111
Phone: 415.227.0100

ASSOCIATE ARCHITECTS:

RATCLIFF

5856 Doyle Street, Emeryville, CA 94608
Phone: 510.899.6400

SHAH KAWASAKI ARCHITECTS

1111 Broadway, Suite 1650, Oakland, CA 94607
Phone: 510.663.6090

All reproduction & intellectual property rights reserved © 2011
In Association with

BKF Engineers

Structural Engineers
Civil Engineers

Degenkolb

Mechanical/Plumbing Engineers

Gutmann & Blaesovet

Consulting Engineers

F.W. Associates, Inc.

Information Systems Engineers

TEECOM Design Group

Medical Equipment Planning

Criterion Systems, Inc.

Landscaping Architects

Keller Mitchell & Co.

Food Service Consultant

William Caruso and Associates

Signage Consultant


Square Peg Design

Seals and Signatures

SEALS AND SIGNATURES



KEY PLAN

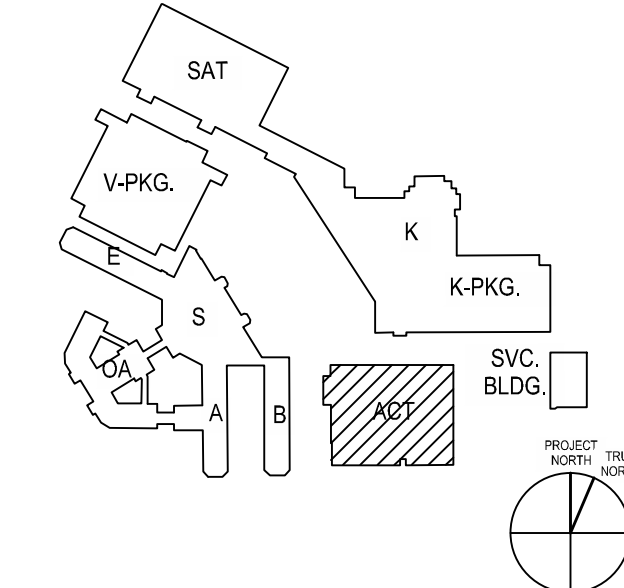

No.	ISSUE DESCRIPTION	DATE
0	INCREMENT 4 14 PERMIT SET ACD 14-051	14 OCT 11 13 DEC 12 17 JAN 14

ACUTE CARE TOWER

DRAWING TITLE

FLOOR PLAN LEVEL 8

SCALE 1/8" = 1'-0"

OSHPD NO. IS101717-4

PROJECT NUMBER 38385.000

DRAWING NUMBER

14-T2.8.0



SHEET NOTES

- SERVE TELECOMMUNICATIONS DEVICES ON THIS SHEET FROM IDF-HD9204.
- PATHWAYS SHOWN DEDICATED FOR LOW VOLTAGE CABLING ONLY, UON.
- PATHWAYS ROUTES SHOWN CONCEPTUAL FIELD COORDINATE FINAL ROUTES.
- FIRESTOP PENETRATIONS (SLEEVES AND CONDUITS) THROUGH RATED WALLS AND FLOORS TO MATCH WALL RATING.
- WHERE SHOWN, ARCHITECTURAL PLANS GOVERN EXACT LOCATION OF TELECOMMUNICATIONS DEVICES.
- LABEL CONDUITS AT BOTH ENDS. LABEL MUST INDICATE CONDUIT'S DEDICATED USE FOR TELECOMMUNICATIONS CABLING AND LOCATION OF THE CONDUIT'S FAR END.
- PROVIDE BUSHINGS ON CONDUIT AND SLEEVE ENDS.
- FOR TELECOM PATHWAYS ENTERING THE TELECOM ROOM, REFER TO 14-T0.10.0 FOR SIZE, QUANTITY, AND TYPE.

KEYED NOTES

ELECTRICAL:

- E-1 PROVIDE RISER CONDUITS TO FLOOR BELOW.
- E-2 ROUTE DEVICE CONDUIT TO CABLE TRAY ON LEVEL BELOW.
- E-3 ROUTE DEVICE CONDUIT DOWN ADJACENT FULL HEIGHT WALL OR FURRED-OUT COLUMN.
- E-4 STUB OUTLET CONDUIT INTO CORRIDOR.
- E-5 HOMERUN OUTLET CONDUIT TO IDF-HD9204.

ALAMEDA COUNTY MEDICAL CENTER



HIGHLAND HOSPITAL
Acute Tower Replacement Project
1411 EAST 31ST STREET, OAKLAND, CA 94612

PREPARED FOR:



GENERAL SERVICES AGENCY
COUNTY OF ALAMEDA
1401 LAKESIDE DRIVE, 10TH FLOOR
OAKLAND, CA 94612

DESIGN/BUILDER



7677 Oakport Street, Suite 1040, Oakland, CA 94621
Phone: 510.430.1700 Fax: 510.430.1705

ARCHITECT:

SMITHGROUP

301 Battery Street, 7th Floor, San Francisco, CA 94111
Phone: 415.227.0100

ASSOCIATE ARCHITECTS:

RATCLIFF

5856 Doyle Street, Emeryville, CA 94608
Phone: 510.899.6400

SHAH KAWASAKI ARCHITECTS

1111 Broadway, Suite 1650, Oakland, CA 94607
Phone: 510.683.6090

All reproduction & intellectual property rights reserved © 2011
In Association with

BKF Engineers

Civil Engineers

Degenkolb

Structural Engineers

Guttmann & Blaesovot

Mechanical/Plumbing Engineers

F.W. Associates, Inc.

Consulting Engineers

TEECOM Design Group

Information Systems Engineers

Criterion Systems, Inc.

Medical Equipment Planning

Keller Mitchell & Co.

Landscape Architects

William Caruso and Associates

Food Service Consultant


Square Peg Design

Signage Consultant

SEALS AND SIGNATURES



KEY PLAN

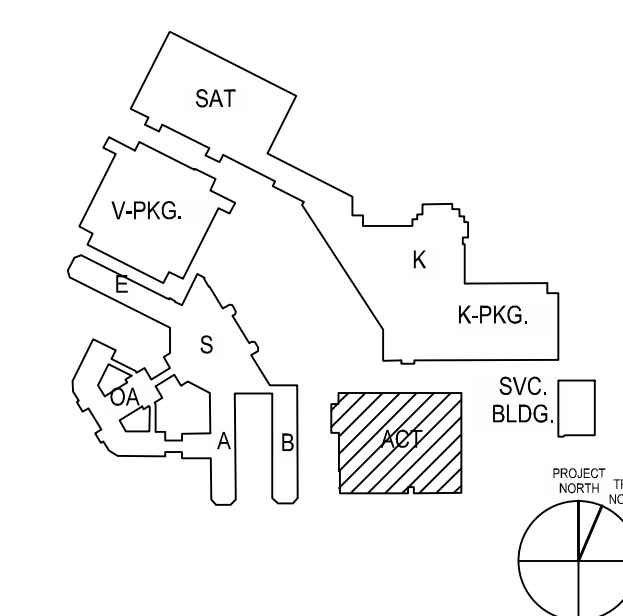

No.	ISSUE DESCRIPTION	DATE
0	INCREMENT 4 14 PERMIT SET ACD 14-051	14 OCT 11 13 DEC 12 17 JAN 14

ACUTE CARE TOWER

DRAWING TITLE

FLOOR PLAN LEVEL 9

SCALE 1/8" = 1'-0"

OSHPD NO. IS101717-4

PROJECT NUMBER 38385.000

DRAWING NUMBER

14-T2.9.0